


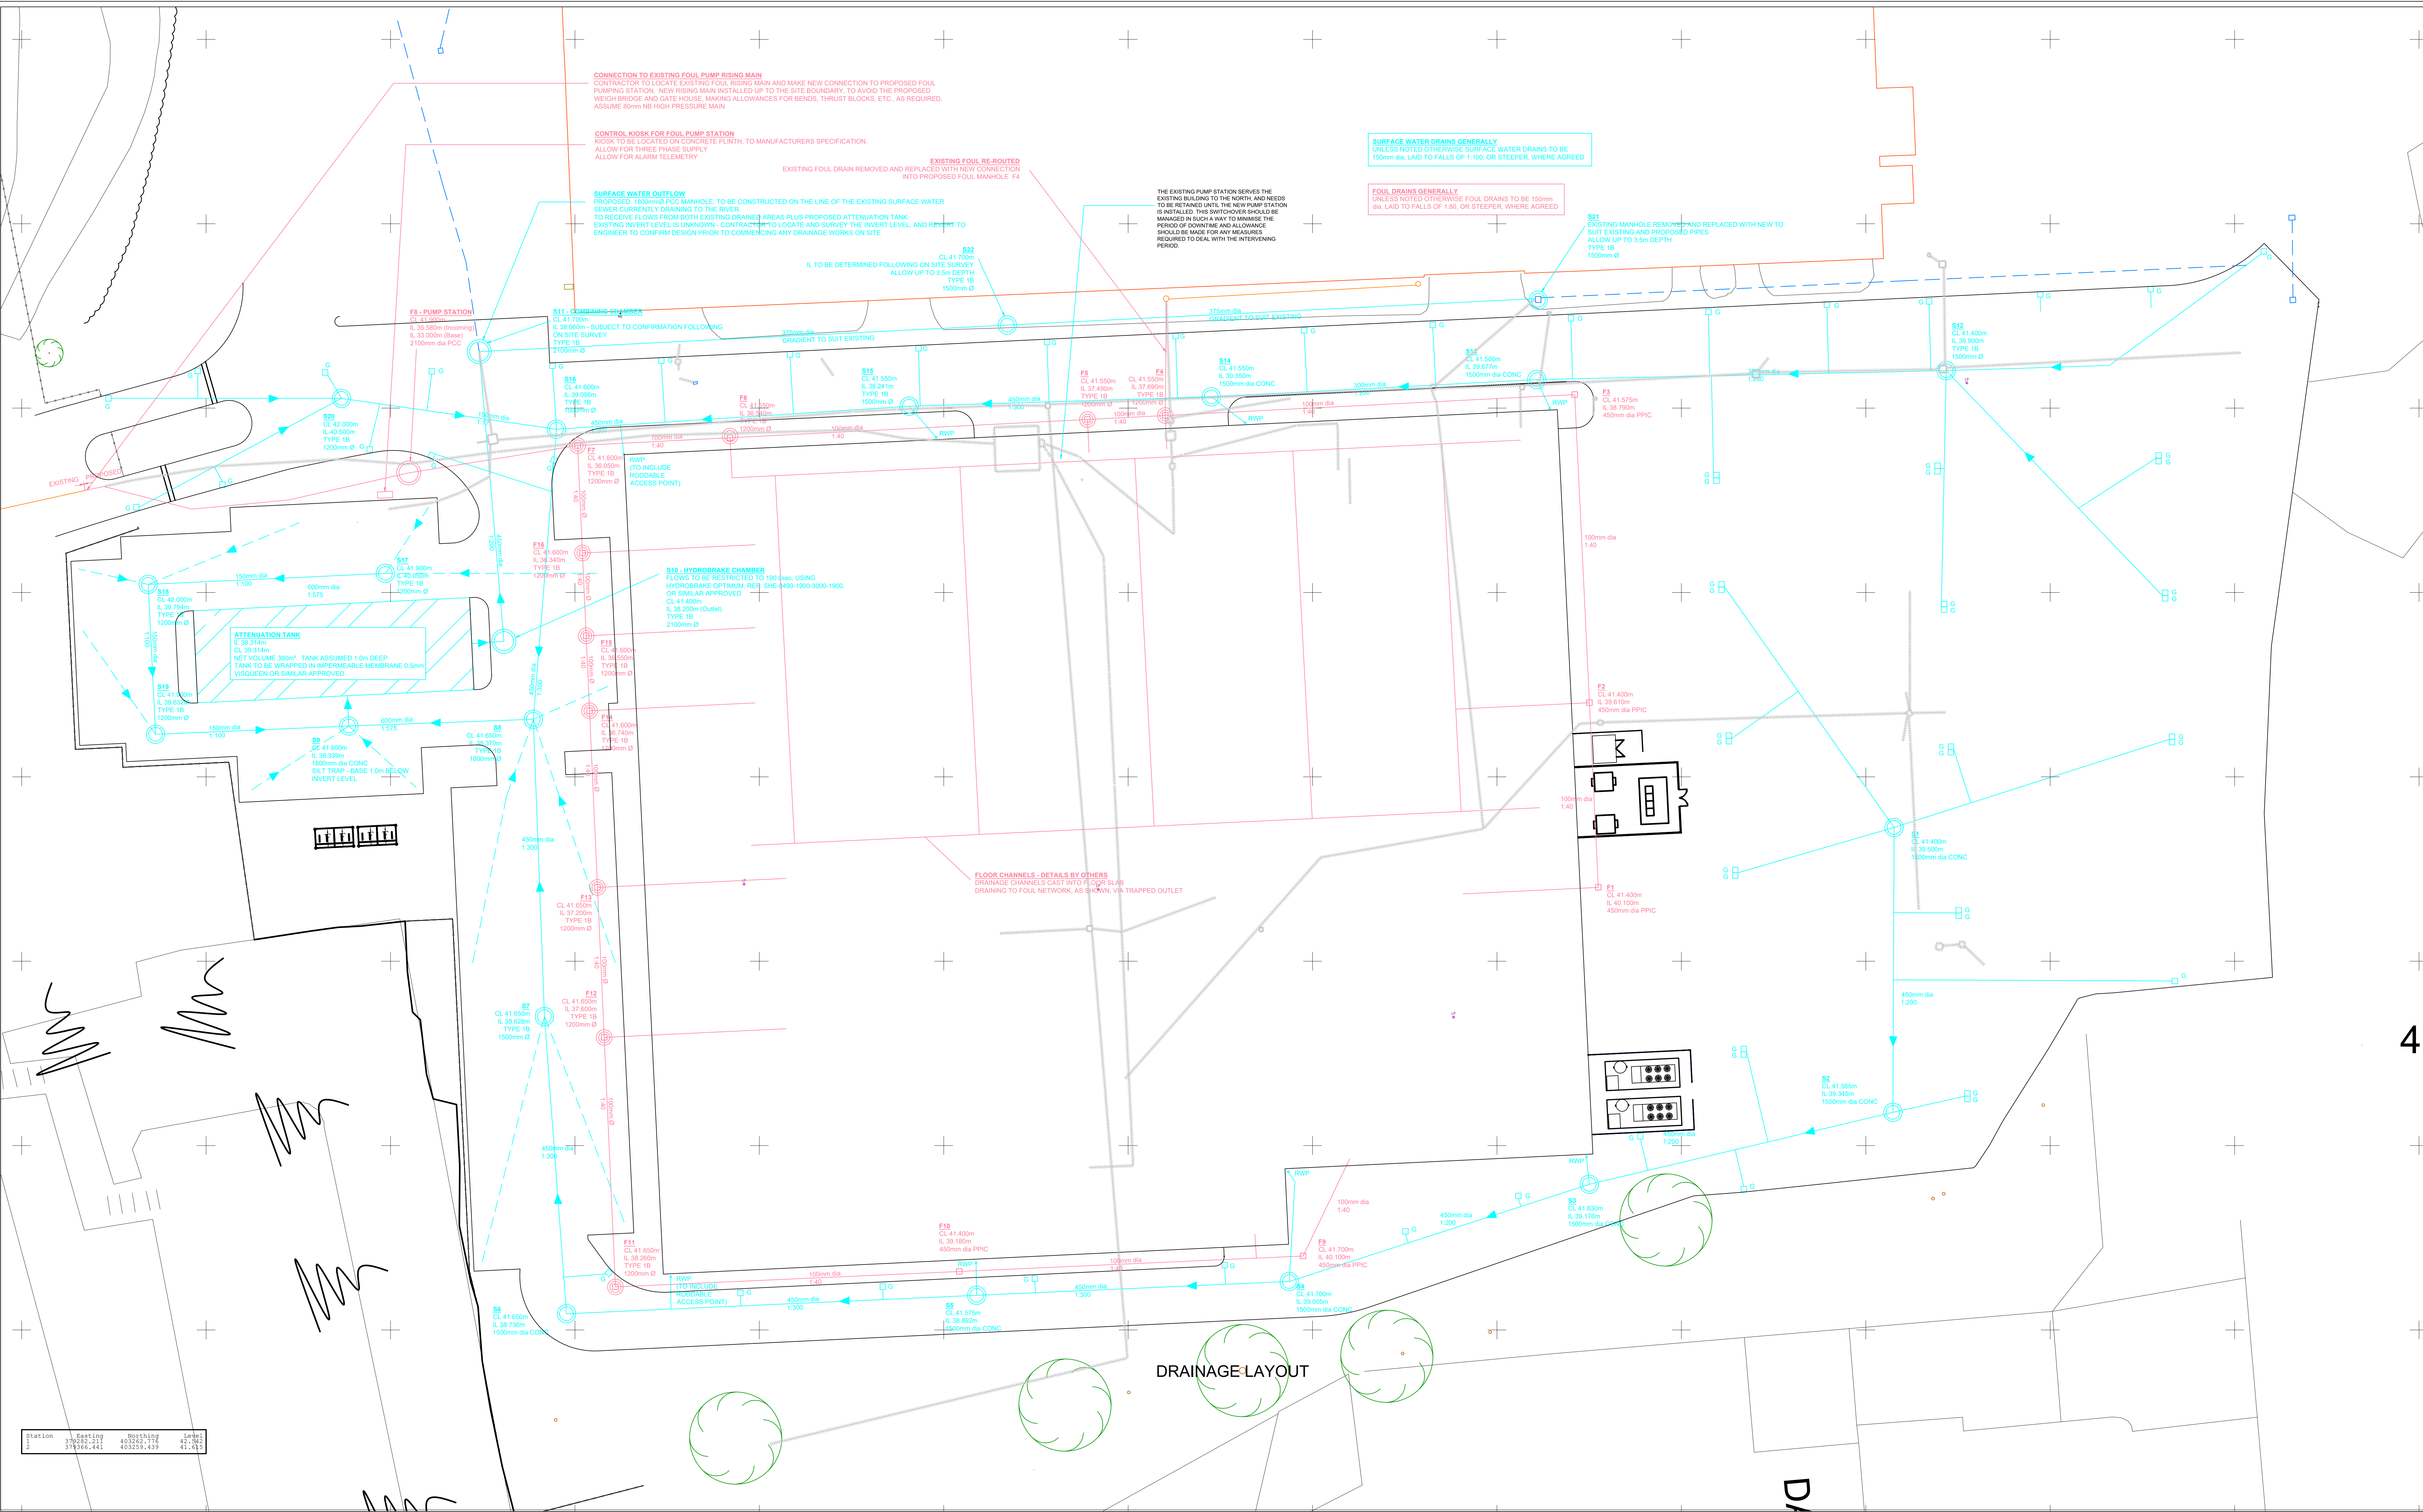

GENERAL NOTES

1.1 ALL DIMENSIONS ARE IN MILLIMETERS UNLESS NOTED OTHERWISE.
1.2 ALL LEVELS ARE IN METERS UNLESS NOTED OTHERWISE.
1.3 ALL DIMENSIONS AND LEVELS ARE APPROXIMATE AND ARE TO BE CHECKED ON SITE PRIOR TO COMMENCEMENT OF THE WORKS.

LEGEND

PRIVATE SEWERS
FOUL

SURFACE WATER PERFORATED DRAIN
SURFACE WATER MANHOLE
TYPE 3 SURFACE WATER INSPECTION CHAMBER
TYPE 4 SURFACE WATER INSPECTION CHAMBER
SURFACE WATER ROODING EYE
FOUL MANHOLE
FOUL INSPECTION CHAMBER (WITH OPENING LIMITED TO 300mm)
EXISTING DRAINAGE TO BE REMOVED

DRAINAGE CHANNEL
SOIL AND VENT PIPE
WC WASTE
KITCHEN WASTE
BATH WASTE
RAIN WATER PIPE
ROAD GULLY

Rev	Date	Description	By
P03	20/03/21	DRAINAGE AMENDED TO SUIT SURVEY DATA	EP
P02	02/03/21	NOTE ADDED AS CLOUDED	CP
P01	28/04/21	FIRST ISSUE	CP

Annotations

Project
ROYDON, RAKE LANE, SWINTON

Title
DRAINAGE LAYOUT

Client
ROYDON

HOLLOWAY JENNINGS
Consulting Civil & Structural Engineers

Corraught House, Park View, Lofthouse
Wakefield, WF2 5BA
01924 441 443
admin@hjcpe.co.uk www.hjcpe.co.uk

Status
TENDER

Designed By	EP	Checked By	SC	HJCE Ref.	5519	
Drawn By	EP	Date	APR 2021	Scale @ A0	1:250 @ A0 UNO	
Project	Originator	Volume	Level	Type	Room	Revision
5519-HJCE-XX-ZZ-DR-D-3001						P03

